


Layout Tab Name: C-701 PHOTOMETRIC PLAN
Last Saved By: Hadley, 9/25/2026 1:57:35 PM
W:\Srvn\Uc\Way\Claris\Indiana Life Science Center\082429 Indiana Life Science Center\082429-ITG.dwg Plotted: September 25, 2026, 2:31:32 PM

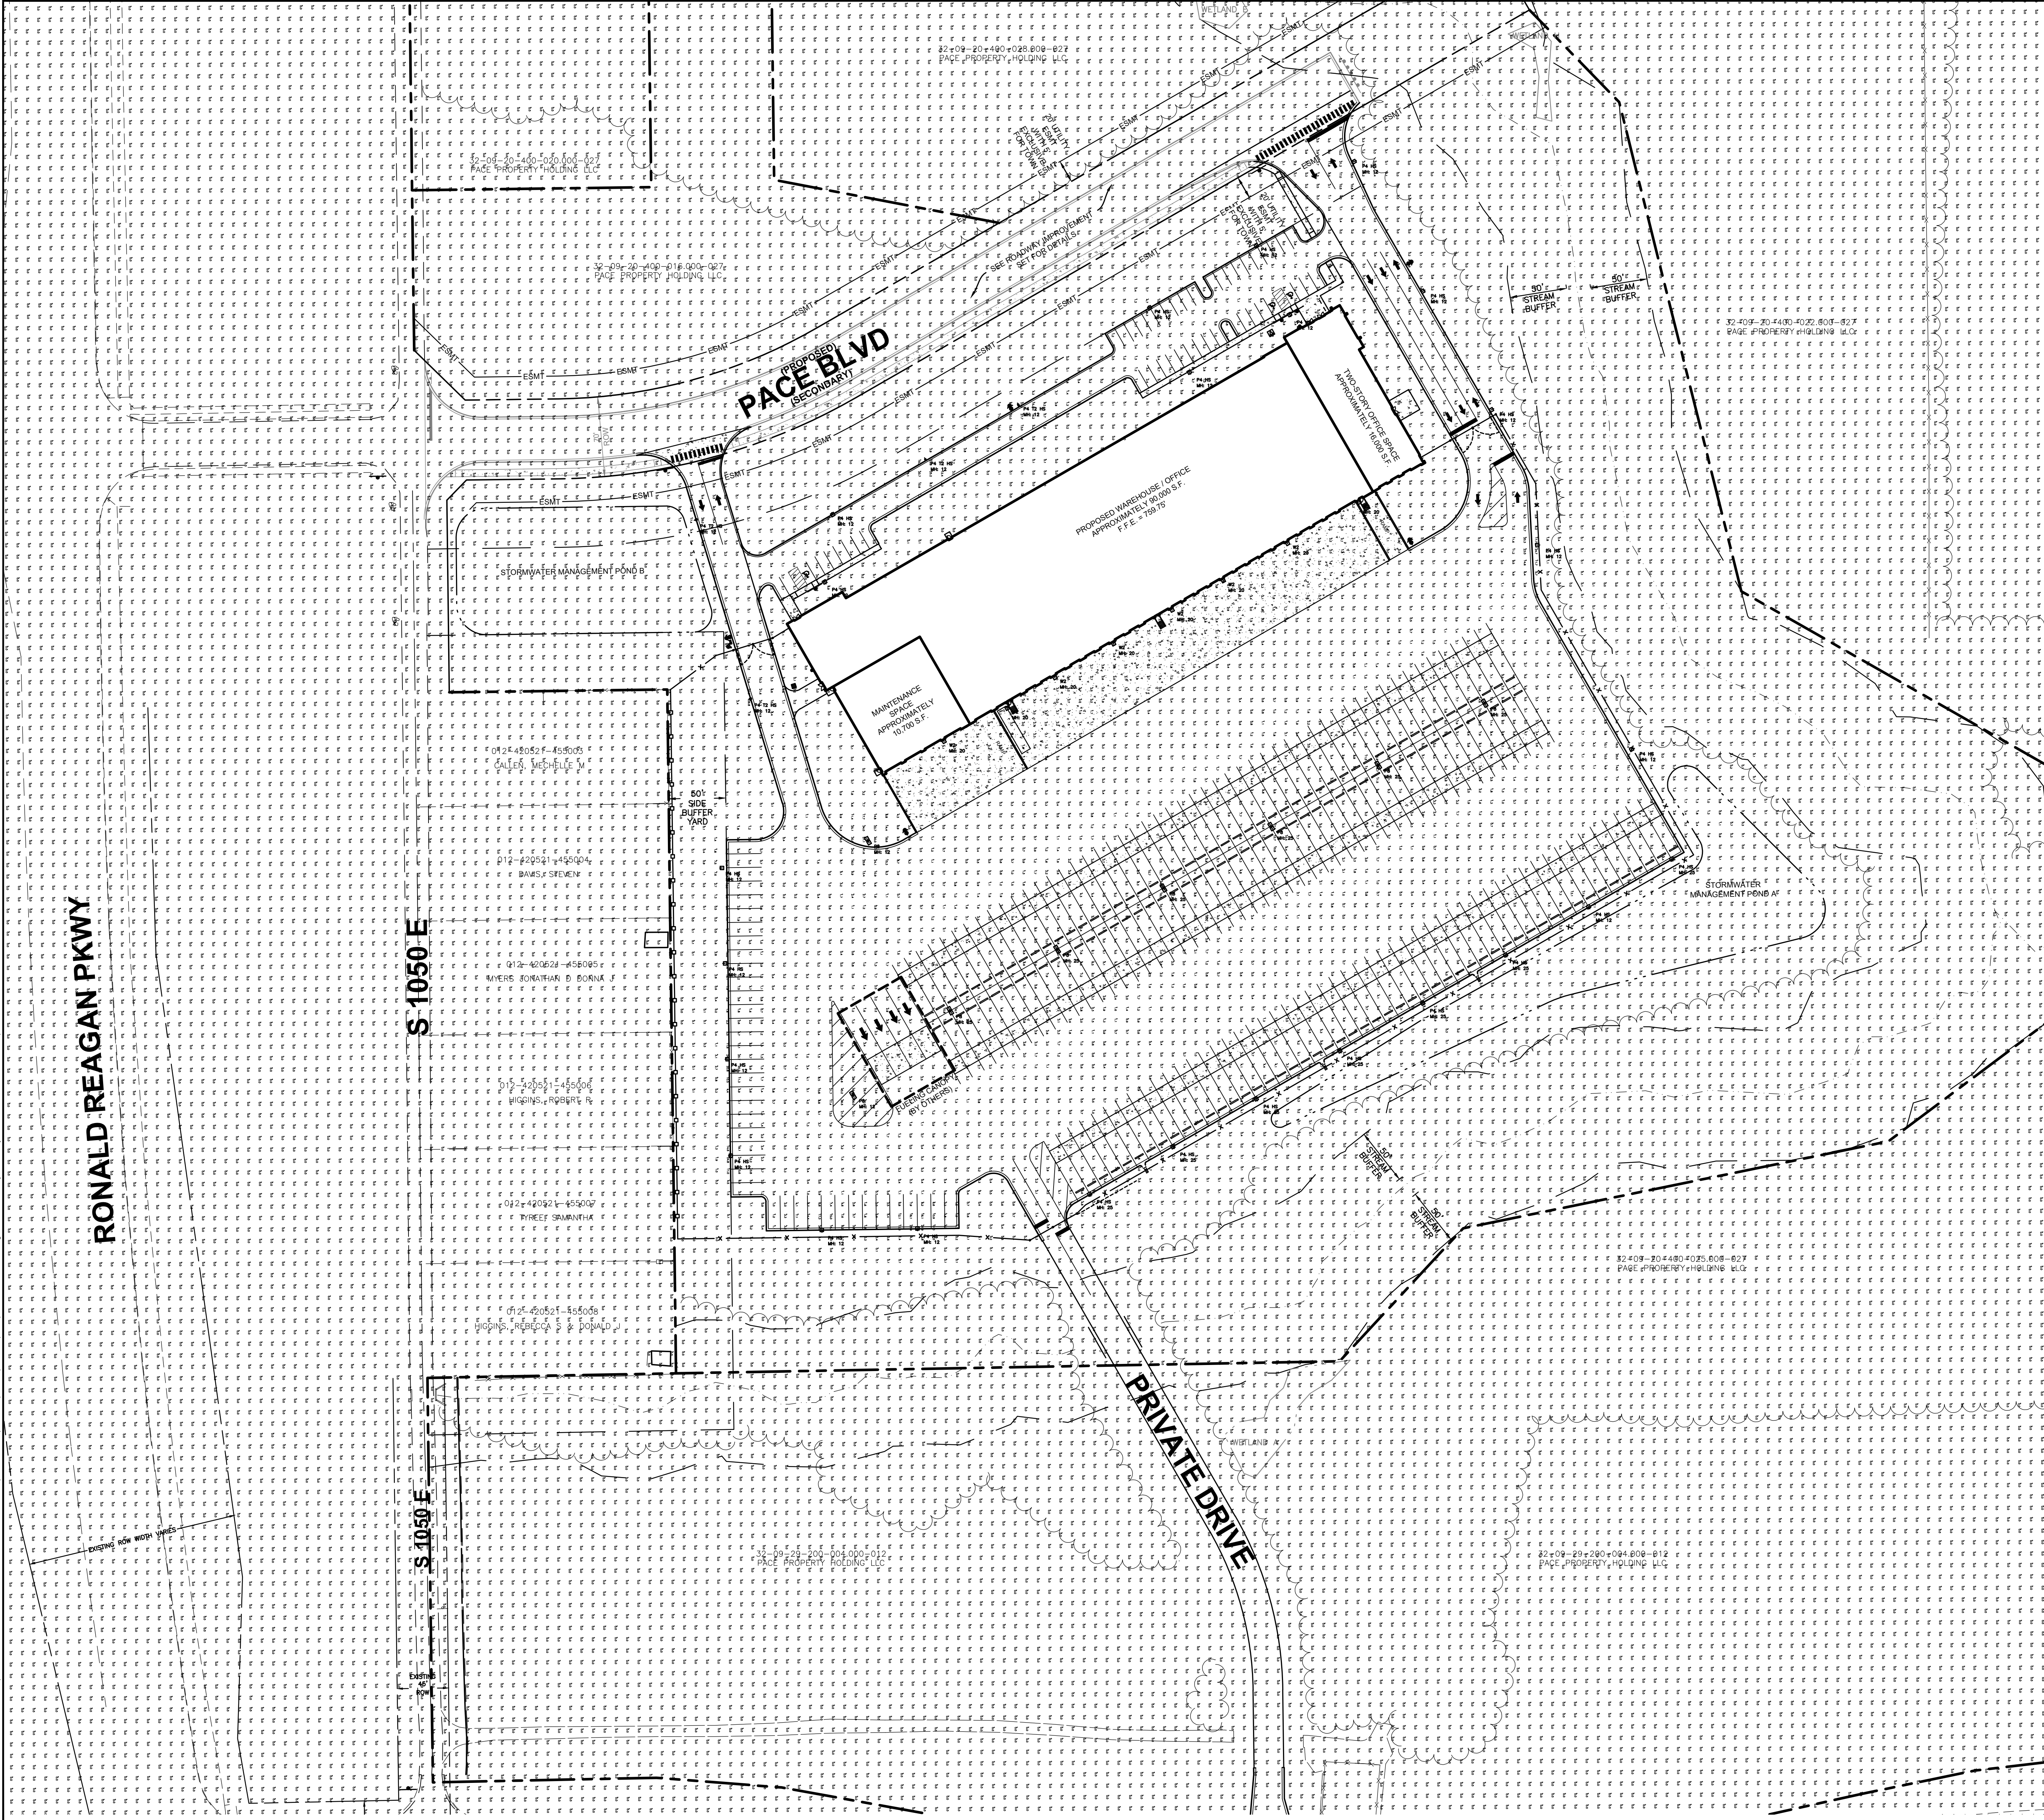

Luminaire Schedule								
Symbol	Qty	Tag	Arrangement	Description	LLF	Luminaire Lumens	Luminaire Watts	Total Watts
	25	P4 HS	Single	DSX2 LED P4 40K T4M MVOLT HS	0.900	25365	270	6750
	8	W2	Single	DSXW2 LED 30C 1000 40K T4M MVOLT	0.900	11128	109	872
	8	P8	Back-Back	DSX2 LED P8 40K T4M MVOLT	0.900	48142	431	8996
	4	P4 T2 HS	Single	DSX2 LED P4 40K T2M MVOLT HS	0.900	27301	270	1080

NOTES

1. MOUNTING HEIGHT (MH) VARIES. SEE FIXTURE LABEL ON PLAN.
2. HORIZONTAL MEASUREMENTS TAKEN ALONG A HORIZONTAL PLANE AT GRADE.
3. REFER TO ARCHITECTURAL DESIGN PLANS FOR LIGHT POLE BASE DETAIL.



ISSUANCE SCHEDULE
NUMBER DATE DESCRIPTION

 
PACE AIR FREIGHT
PACE AIR FREIGHT HEADQUARTERS
SITE IMPROVEMENT PLANS
ISSUED FOR SITE INFRASTRUCTURE SUBMITTAL
2863 S. COUNTY ROAD 1050 E
PLAINFIELD, INDIANA 46168

PROJECT NO: 82429.12
DATE ISSUED: 09/22/2026
DESIGNED BY: XXX
DRAWN BY: XXX
CHECKED BY: XXX

SHEET NAME:
PHOTOMETRIC PLAN

SHEET NO:

C-701



OUTDOOR: One Lithonia Way, Conyers, GA 30012 Phone: 800-705-SERV (7378) www.lithonia.com ©1994-2021 Acuity Brands Lighting, Inc. All rights reserved. Rev. 01/22/2

